


MEGAWATTS

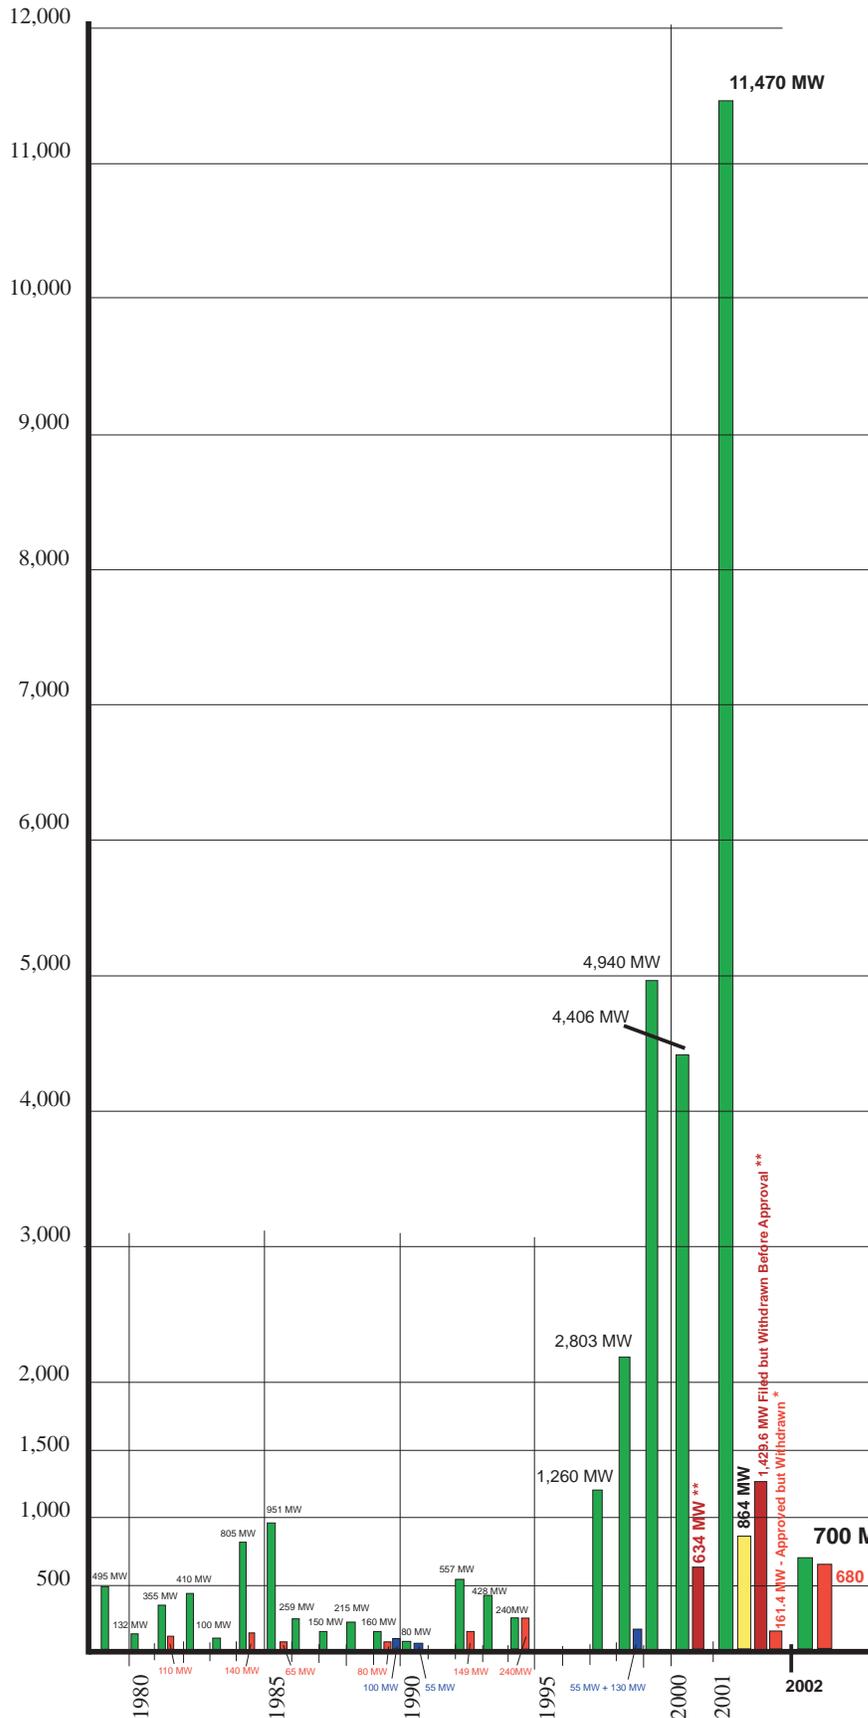

- Power Plant Cases Filed by Year
- Power Plants Approved But Not Built *
- Power Plants Closed
- Emergency Peaking Power Plants Approved and To Be Built
- Projects filed but withdrawn by applicant before approval **

NOTES

* Projects Approved but Withdrawn

Filed Name	Withdraw	MW
2000 Hanford	2001	99
2001 RAMCO	2001	62.4
2001 Pegasus	2002	180
2001 Colusa	2002	500

** Projects Filed but Withdrawn

In 2000, seven projects (634 MW) filed but withdrawn before approval.

In 2001, six projects totalling (1,429.6 MW) filed but withdrawn before approval. These were: CENCO (50 MW), La Jolla Baldwin (53 MW), Lancaster (240 MW), Malburg (80.6 MW), Nueva Azalea (550 MW), and Ocotillo (456 MW).